

NICHOLS
MELBURG
ROSETTO

ARCHITECTS + ENGINEERS

300 KNOLLCREST DRIVE


REDDING, CA 96002

(530) 222-3300 (530) 222-3538 FAX

<http://www.nmrdesign.com>

CONSULTANTS

LICENSE STAMPS

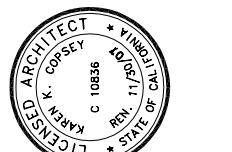

PROJECT NAME
**COLLEGE OF THE
SISKIYOUS**

**TACTICAL
TRAINING
SUPPORT CTR**

WEED, CALIFORNIA

SHEET TITLE
**EXTERIOR
ELEVATIONS**

DRAWING STATUS
**CONSTRUCTION
DOCUMENTS**

DSA SUBMITTAL

REVISIONS
Sym. Description By Date

Drawn By AK

Checked By WK

Date Drawn 03/07


Scale AS NOTED

Job No. 06-2327

SHEET No.


KEYNOTES

- 1 WIND SCREEN A8.3
- 2 METAL LOUVER A8.3
- 3 STANDING SEAM METAL ROOFING 5 A8.3
- 4 OVERHEAD COILING DOOR 8 A8.1
- 5 FURRED COLUMN 8 A8.2
- 6 ALUMINUM WINDOW
- 7 HM. DOOR & FRAME

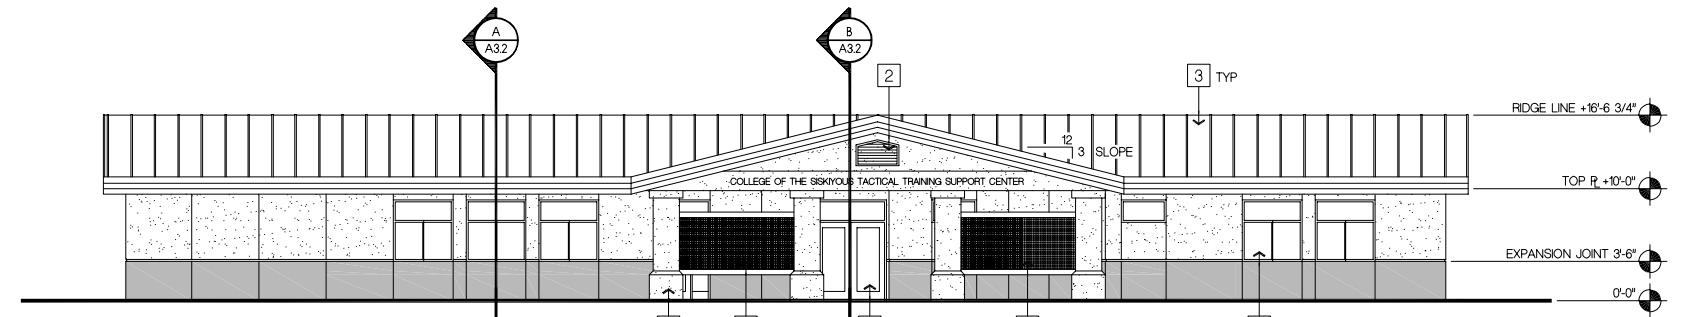


SOUTH ELEVATION

SCALE 1/8=1'-0"

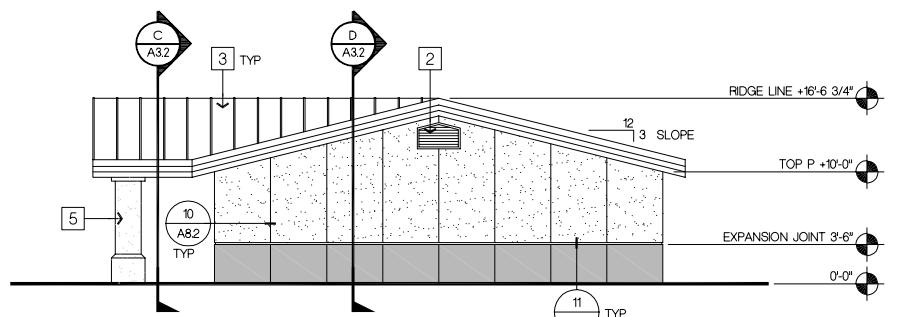


EAST ELEVATION

SCALE 1/8=1'-0"

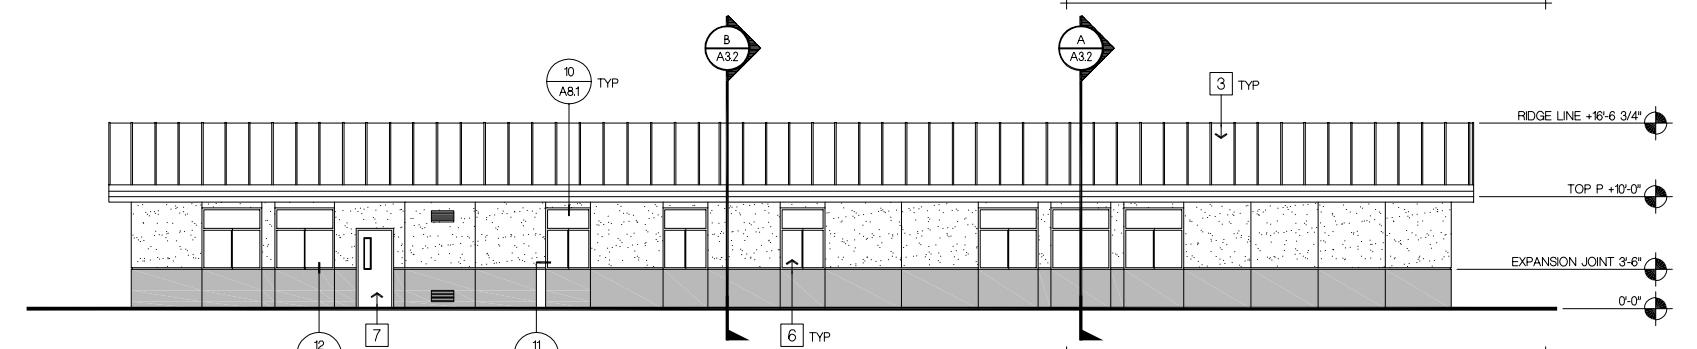

NORTH ELEVATION

SCALE 1/8=1'-0"

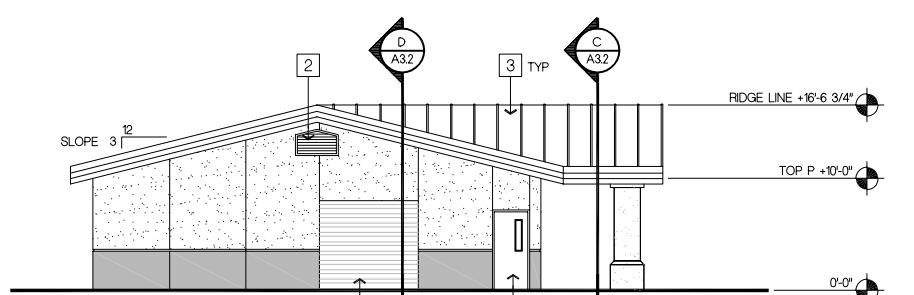

WEST ELEVATION

SCALE 1/8=1'-0"

LEGEND



CEMENT PLASTER SYSTEM COLOR # 1



CEMENT PLASTER SYSTEM COLOR # 2

APPROVALS